

Dist	COUNTY	ROUTE	POST MILES TOTAL PROJECT	SHEET No.	TOTAL SHEETS

REGISTERED CIVIL ENGINEER DATE \_\_\_\_\_

PLANS APPROVAL DATE \_\_\_\_\_

THE STATE OF CALIFORNIA OR ITS OFFICERS OR AGENTS SHALL NOT BE RESPONSIBLE FOR THE ACCURACY OR COMPLETENESS OF SCANNED COPIES OF THIS PLAN SHEET.



# STAGE CONSTRUCTION AND TRAFFIC HANDLING PLAN SHEET, EXAMPLE "70 SC-1"

Title  
FT=43, TX = 12, WT=0  
LV=rd\_LAYOUT-NOTE-anno

Sub-Title  
FT=3, TX = 8.75, WT=2  
LV=rd\_LAYOUT-NOTE-anno  
Underlined (WT=1)


## STAGE 1 CONSTRUCTION WORK TO BE PERFORMED:

- INSTALL TEMPORARY HIGH-VISIBILITY FENCE. FOR ADDITIONAL DETAILS, SEE LAYOUTS.
- INSTALL TEMPORARY LIGHTING SYSTEM (STAGE 1). FOR ADDITIONAL DETAILS, SEE ELECTRICAL PLANS.
- GRIND AND OVERLAY EXISTING CENTERLINE RUMBLE STRIP FROM Sta 254+00 TO 289+00. FOR DETAILS, SEE SHEET SCD-1.
- PLACE TEMPORARY TRAFFIC CONTROL DEVICES AND TEMPORARY PAVEMENT DELINEATION PER THESE SHEETS.
- PLACE TEMPORARY STRIPING.
- PLACE TEMPORARY RAILING (TYPE K) AND ALTERNATIVE TEMPORARY CRASH CUSHIONS THIS STAGE.
- PLACE PLASTIC TRAFFIC DRUMS, TYPE III BARRICADES, AND CONSTRUCTION AREA SIGNS THIS STAGE.
- PERFORM CLEARING AND GRUBBING FOR WEST PORTION OF ROUTE 70 WIDENING INCLUDING REMOVAL/ RELOCATION OF EXISTING FENCE, GATES, ROADSIDE SIGNS, CROSS CULVERTS AND TEMPORARY RELOCATION OF MAILBOXES (Sta "A" 230+00 TO "A" 309+00). REMOVE TREES.
- CONSTRUCT WEST PORTION OF ROUTE 70 ROADWAY WIDENING FROM Sta "A" 230+50 TO Sta "A" 309+00.
- CONSTRUCT DRAINAGE SYSTEMS. FOR ADDITIONAL INFORMATION, SEE DRAINAGE PLAN, DRAINAGE PROFILES AND DETAILS.
- CONSTRUCT DRIVEWAY IMPROVEMENTS FOR WEST PORTION OF ROUTE 70 (Sta "A" 230+00 TO "A" 309+00).
- PLACE HMA DIKE (TYPE E) (Mod) AND HMA DIKE (TYPE A) (Mod) FOR WEST PORTION OF ROADWAY IMPROVEMENTS (Sta "A" 230+00 TO "A" 309+00). FOR ADDITIONAL INFORMATION, SEE LAYOUTS.
- CONSTRUCT TEMPORARY CROSSOVER (SEE STAGE CONSTRUCTION DETAILS).
- PLACE TEMPORARY PAVEMENT DELINEATION AND CONSTRUCTION AREA SIGNS PER STAGE 2.
- INSTALL TEMPORARY LIGHTING SYSTEM (STAGE 2). FOR ADDITIONAL DETAILS, SEE ELECTRICAL PLAN.
- PLACE PLASTIC TRAFFIC DRUMS, TYPE III BARRICADES AND CONSTRUCTION AREA SIGNS PER STAGE 2.
- PLACE TEMPORARY RAILING (TYPE K) AND ALTERNATIVE TEMPORARY CRASH CUSHIONS PER STAGE 2.
- SHIFT TRAFFIC TO ROADWAY CONSTRUCTED IN STAGE 1.

Notes  
FT=3, TX=7, WT=1  
LV=rd\_LAYOUT-NOTE-anno

**NOTES:**

- FOR ACCURATE RIGHT OF WAY DATA, CONTACT RIGHT OF WAY ENGINEERING AT THE DISTRICT OFFICE.

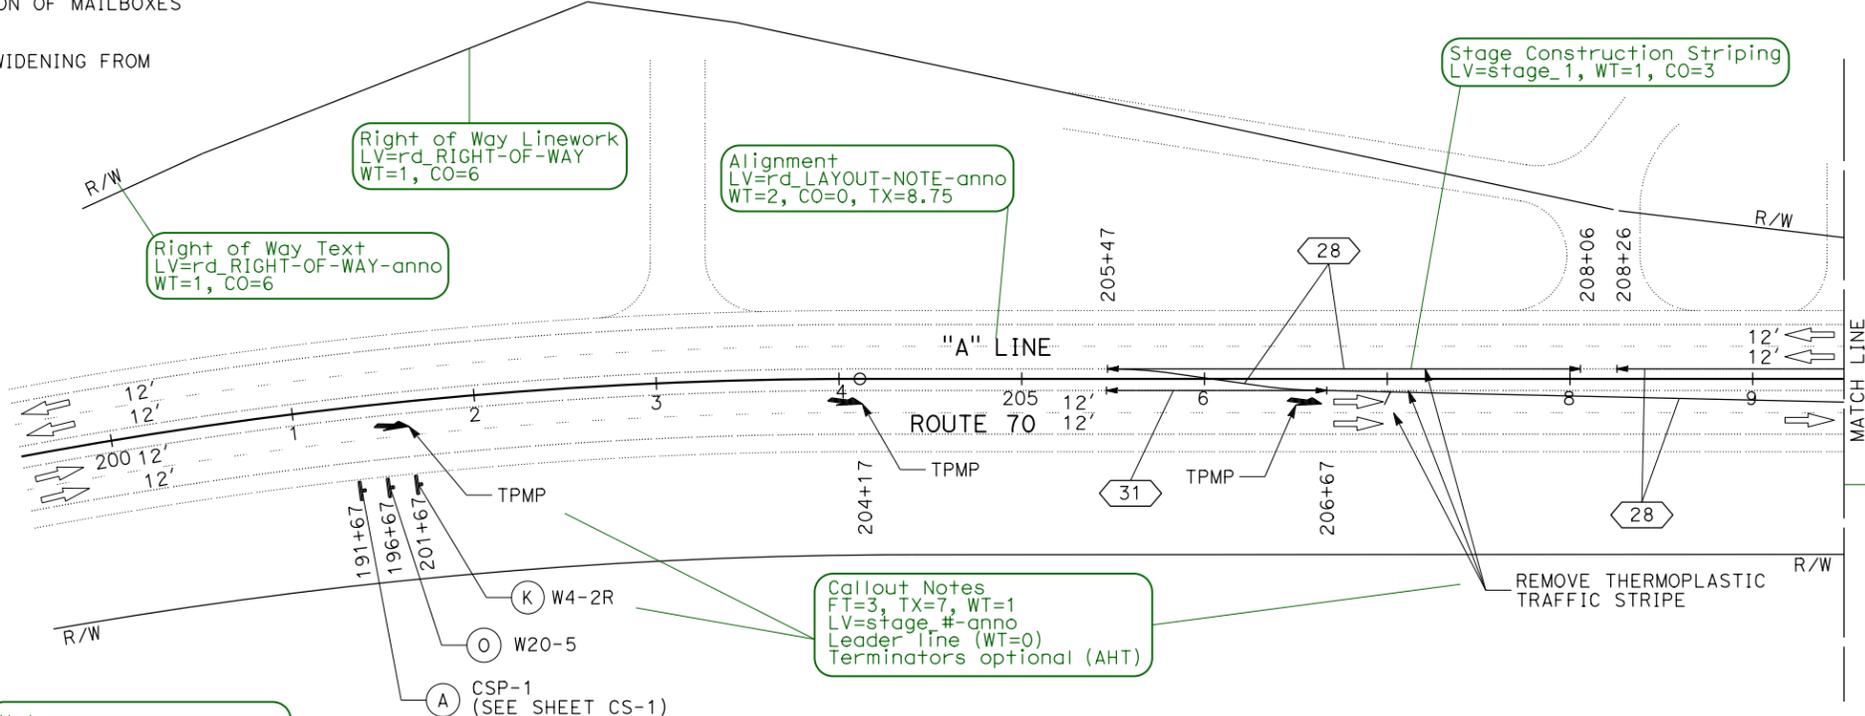

Stage Construction work Level = "Stage\_#", Weight=1, Color=Varies on Stage Number

Stage Level Colors:

1-	3	(Red)
2-	13	(Violet)
3-	8	(Turquoise)
4-	5	(Purple)
5-	14	(Orange)
6-	3	(Red)
7-	13	(Violet)
8-	8	(Turquoise)
9-	5	(Purple)
10-	14	(Orange)


Notes  
FT=3, TX=7, WT=1  
LV=rd\_LAYOUT-NOTE-anno

Callout Notes  
FT=3, TX=7, WT=1  
LV=stage\_#-anno  
Leader line (WT=0)  
Terminators optional (AHT)

Sub-Title  
FT=3, TX=8.75, WT=2  
LV=rd\_LAYOUT-NOTE-anno  
Underlined (WT=1)

Stage Levels:  
Levels are set aside for Stages 1-10 as "Stage\_#"  
Annotation for the current Stage shall be put on the corresponding stage level ending in "-anno"  
Information belonging to a different stage shall be put on the corresponding Stage level ending in "\_drop"

Patterning shall be Weight 0

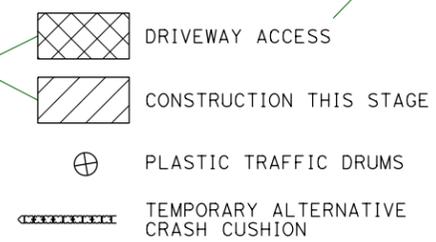

- LEGEND:**
- DRIVeway ACCESS
  - CONSTRUCTION THIS STAGE
  - PLASTIC TRAFFIC DRUMS
  - TEMPORARY ALTERNATIVE CRASH CUSHION
  - TYPE III BARRICADE
  - LIMIT LINE
  - PLASTIC TRAFFIC DRUM SPACING
  - TEMPORARY PAVEMENT MARKING (PAINT)
  - TYPE I ARROW
  - TYPE III ARROW
  - TYPE VI ARROW
  - "STOP" PAVEMENT MARKING
  - CONSTRUCTION AREA SIGN LETTER

Sheet Title and INDEX  
FT=43, TX=14.5, WT=0  
LV=border\_INSIDE-BORDER-anno

Scale  
FT=3, TX=8.75, WT=2  
LV=border\_INSIDE-BORDER-anno

## STAGE CONSTRUCTION AND TRAFFIC HANDLING PLAN STAGE 1 SCALE: 1" = 50'

SC-1

REVISOR: [ ]  
DATE: [ ]  
DESIGNED BY: [ ]  
CHECKED BY: [ ]  
FUNCTIONAL SUPERVISOR: [ ]  
DEPARTMENT OF TRANSPORTATION: [ ]  
STATE OF CALIFORNIA - DEPARTMENT OF TRANSPORTATION: [ ]  
Caltrans

STAGE CONST./ TRAFFIC HANDLING SHEET RELEASED 11/05/2021